



100
0 10
A1

DO NOT SCALE

File: ATK-ZZ-ZZ-DR-CE-900572_900580.dwg
Date: Sep 15, 2026 - 5:42pm
Printed by: SHEER8400

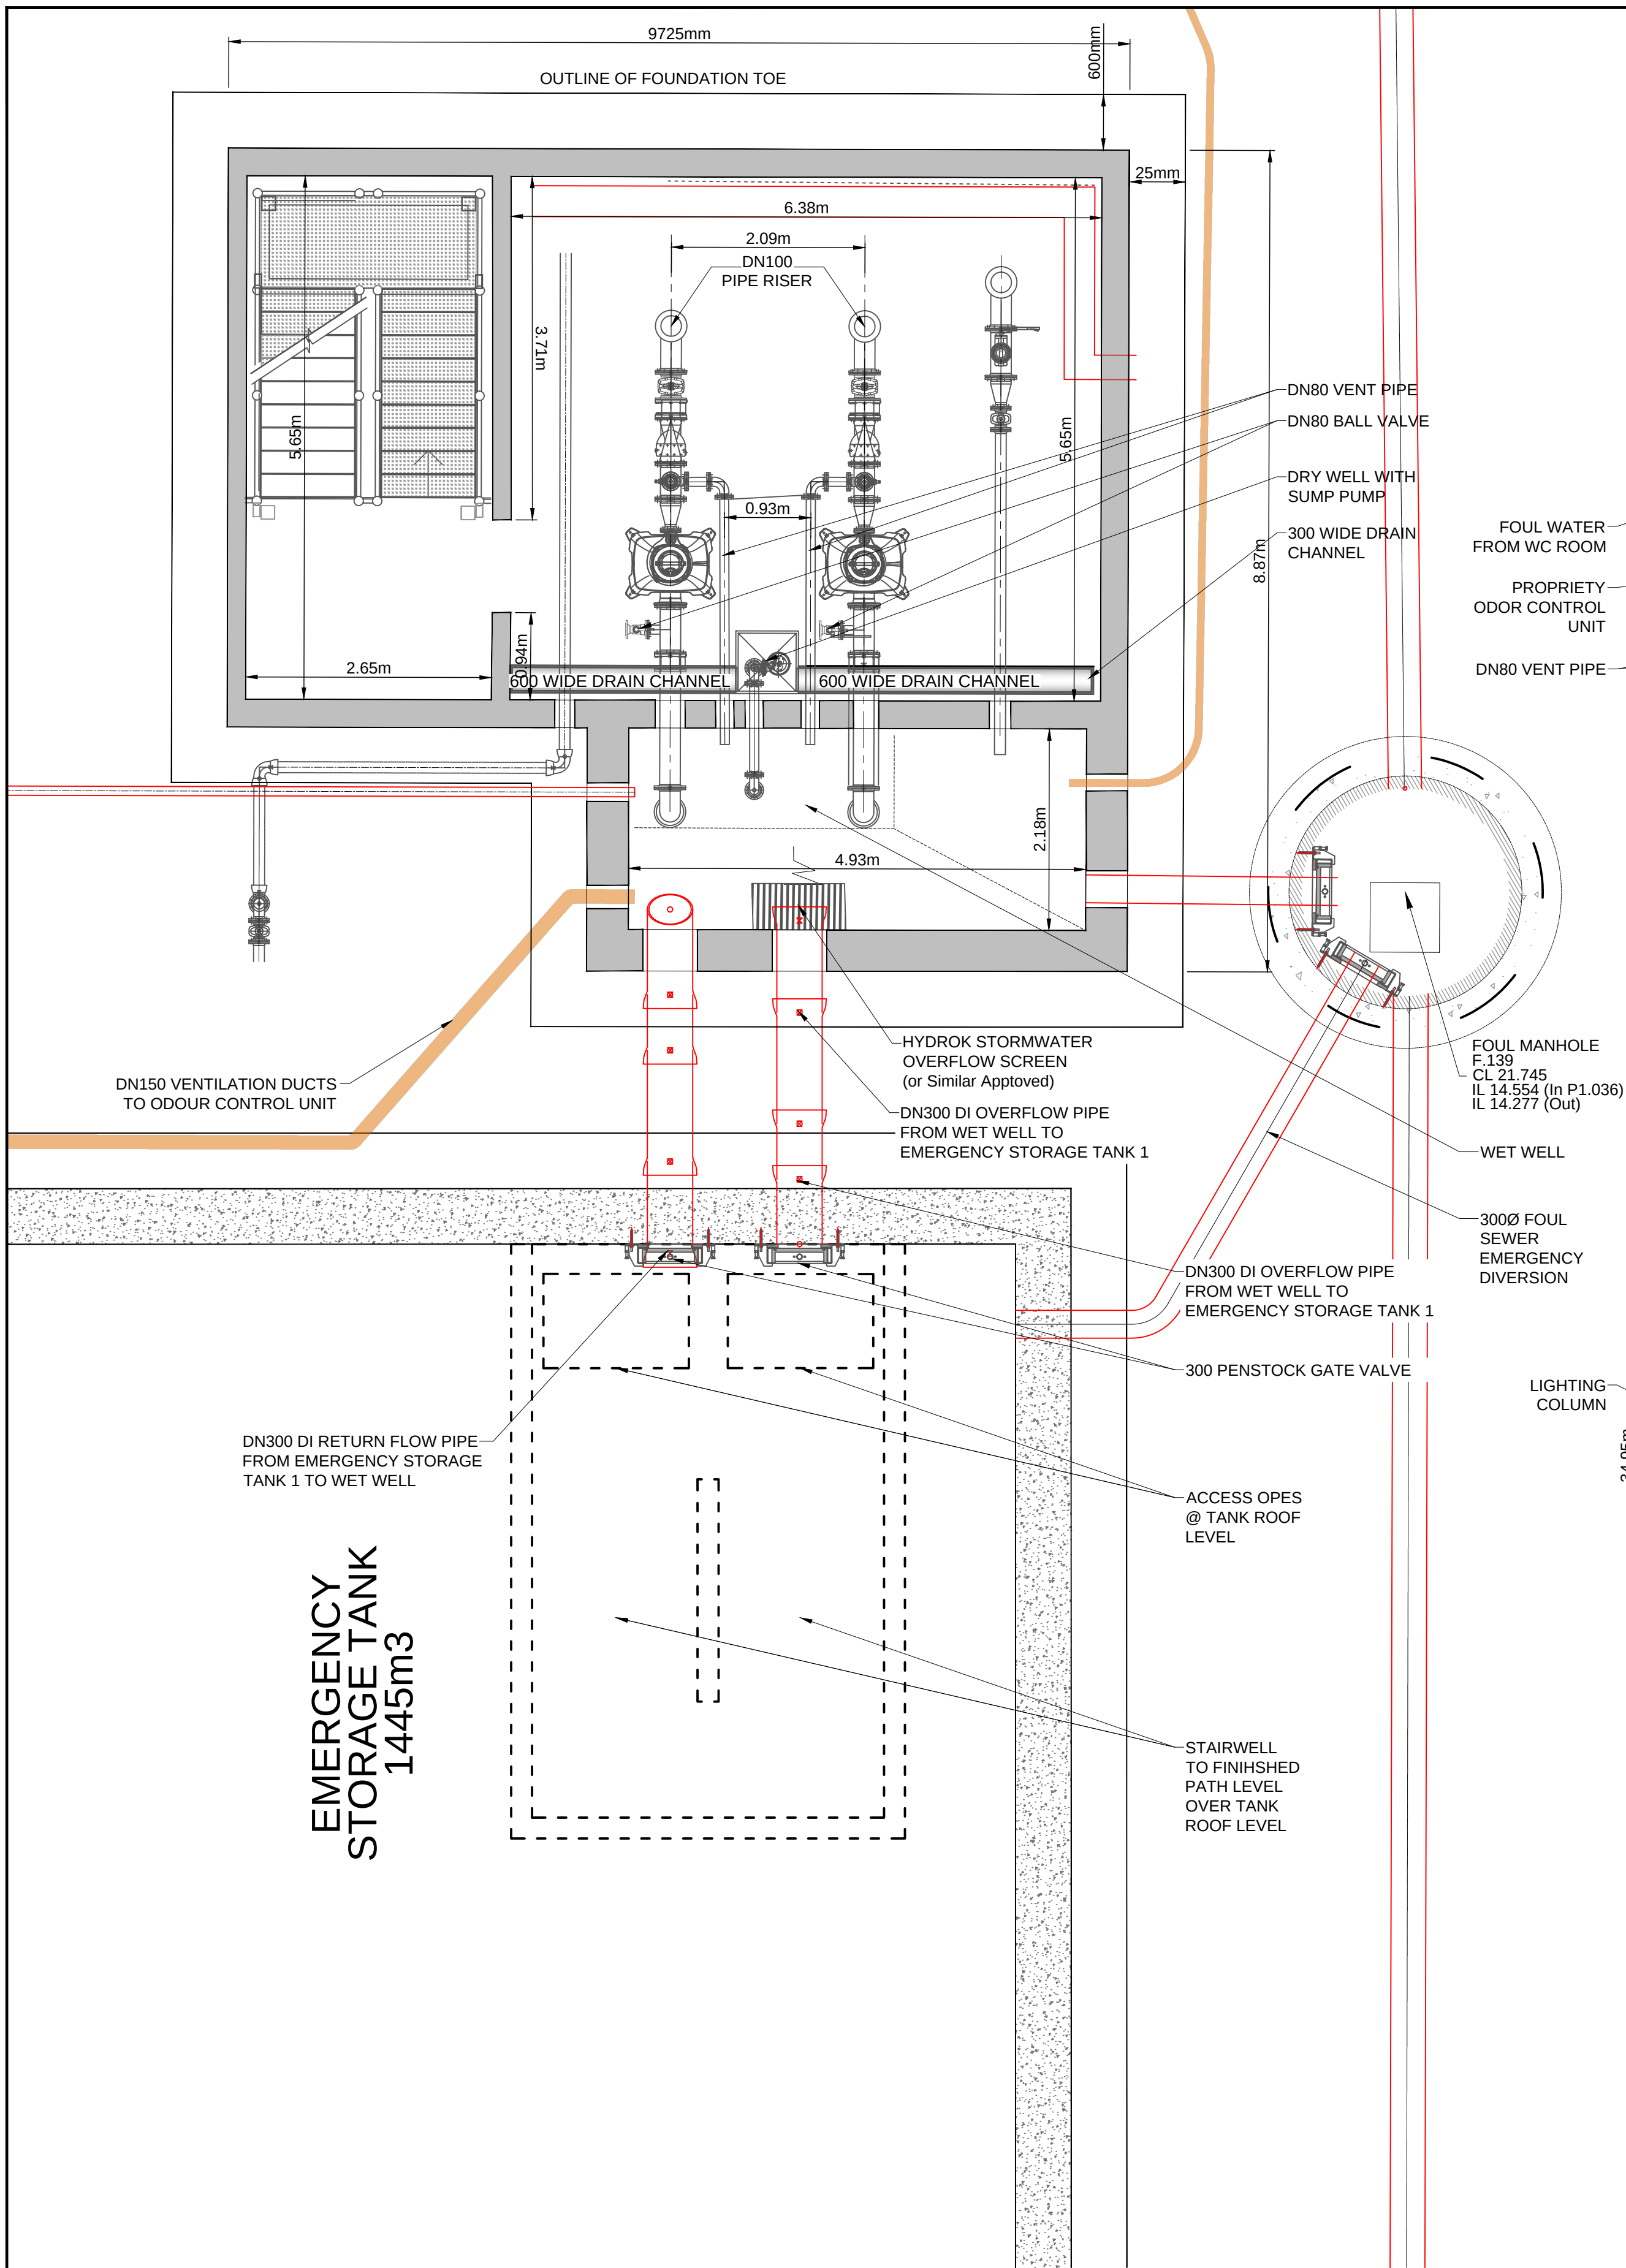

1 WASTE WATER PUMPING STATION DRYWELL FLOOR PLAN
Scale:- 1:150

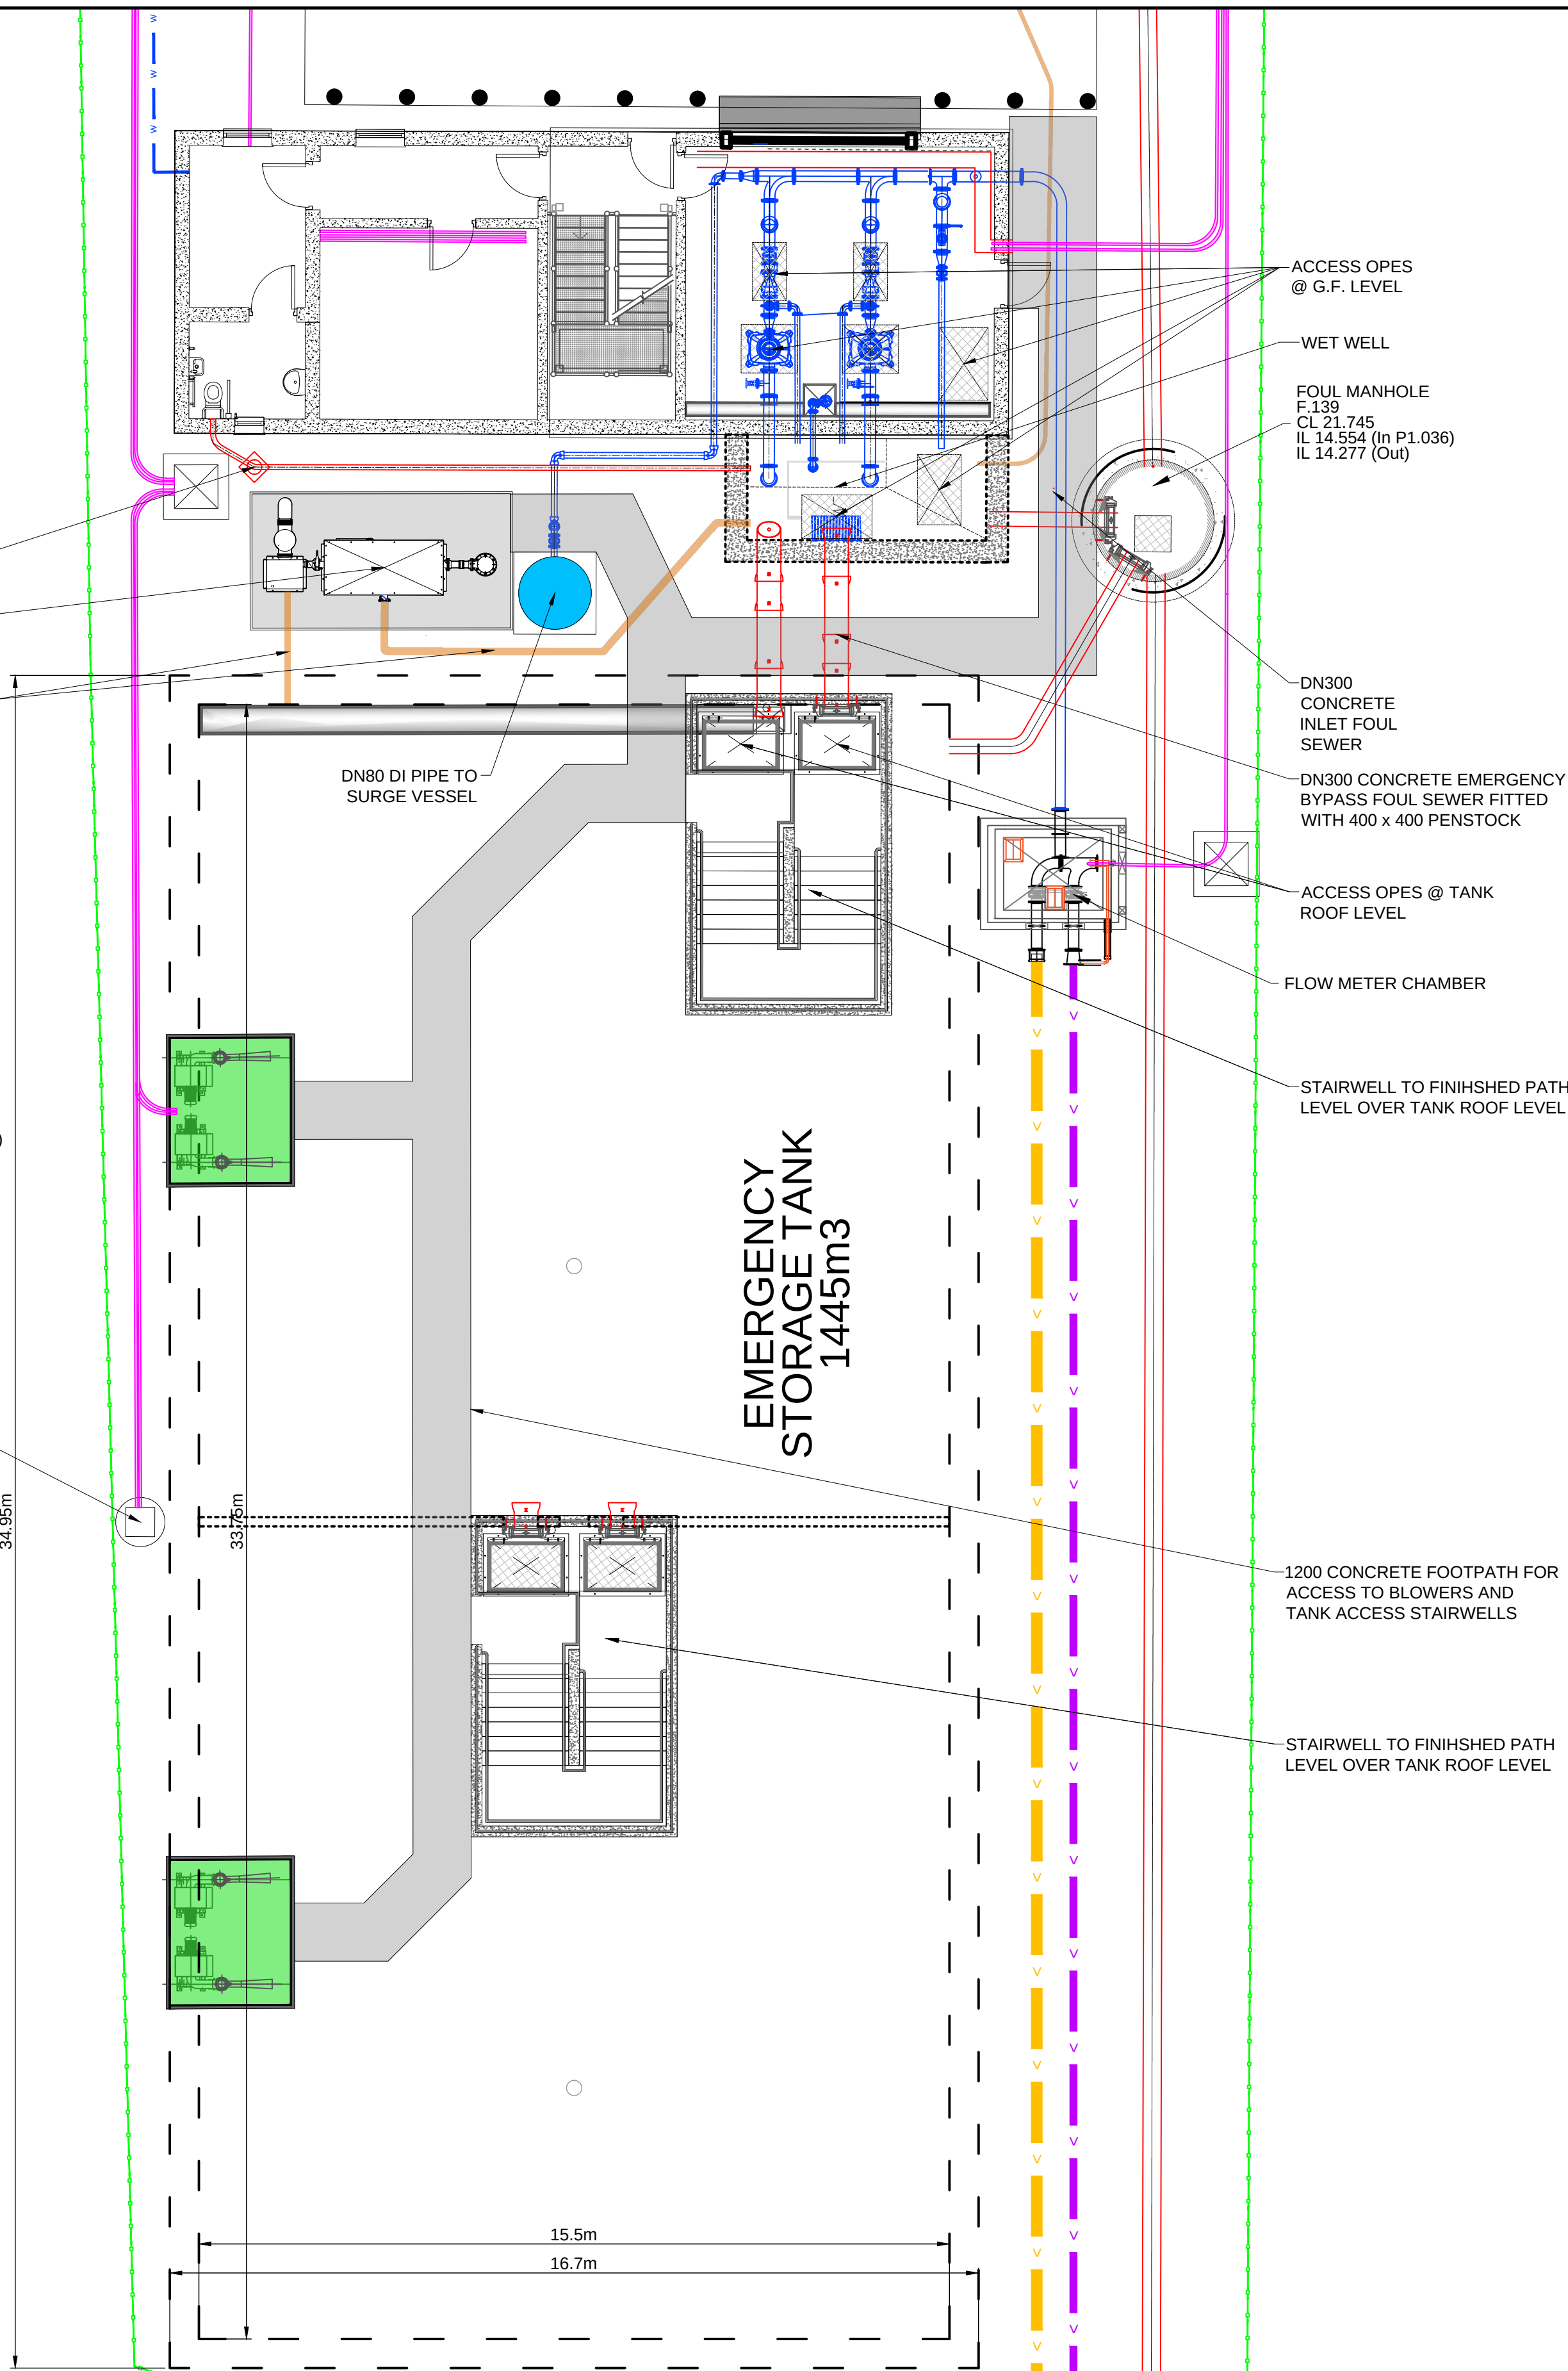

2 WASTE WATER PUMPING STATION GROUND FLOOR PLAN
Scale:- 1:100

- GENERAL NOTES
1. ALL DIMENSIONS ARE IN MILLIMETRES UNLESS NOTED OTHERWISE
 2. ONLY WRITTEN DIMENSIONS SHALL BE USED. NO DIMENSIONS SHALL BE SCALED FROM THE DRAWINGS
 3. ALL LEVELS ARE IN METRES AND ARE TO MALIN HEAD DATUM
 4. ALL COORDINATES ARE IN METRES AND ARE TO IRISH TRANSVERSE MERCATOR
 5. DRAWINGS ARE TO BE READ IN CONJUNCTION WITH THE SPECIFICATION
 6. THE MIXING ARRANGEMENT INCLUDING PIPEWORK AND CHOICE OF MIXERS SHOWN INDICATIVELY AND TO BE DESIGNED BY THE MECHANICAL SUBCONTRACTOR.
 7. PASSIVE/ACTIVE ODOUR CONTROL SELECTION/SIZE WILL BE FINALISED BY UNDERTAKING A DETAILED ASSESSMENT BY THE CONTRACTOR.
 8. INTERCEPTION CHAMBER PROVIDED WITH INTERLOCK VALVE TO BE CLOSED DURING CHEMICAL DELIVERY.
 9. FOR CHEMICAL STORAGE TANK, EMERGENCY SHOWER, ODOUR CONTROL UNIT, FLOWMETER CHAMBER AND DIESEL GENERATOR DETAILS, REFER TO DRAWING ATK-ZZ-ZZ-DR-CE-900577. REQUIREMENTS OF CHEMICAL DOSING SYSTEM WILL BE ASSESSED AND FINALISED BY THE CONTRACTOR"
 10. FOR EMERGENCY STORAGE TANK DETAILS, REFER TO DRAWING ATK-ZZ-ZZ-DR-CE-900575.
 11. FOR WET WELL DETAILS, REFER TO DRAWING ATK-ZZ-ZZ-DR-CE-900576.
 12. SUB-STATION LOCATION IS MARKED INDICATIVELY AND REQUIREMENTS TBC BY E.S.B. DESIGN OF SUB-STATION WILL BE TO A3D-205071-16A Rev C & SPECIFICATION-FOR-MEDIUM-VOLTAGE-(MV)-SUBSTATION-BUILDINGS-(No.13320) FINALISED AT CONSTRUCTION STAGE.

© ORDNANCE SURVEY IRELAND LICENSE NR. AR 0082526. ORDNANCE SURVEY IRELAND & GOVERNMENT OF IRELAND ATKINS WILL NOT BE HELD LIABLE FOR THE USE OF THIS DATA ON ANY PROJECT OTHER THAN THE PROJECT.	
REFERENCE: 1. ATK-ZZ-ZZ-DR-CE-900572 2. ATK-ZZ-ZZ-DR-CE-900574 3. ATK-ZZ-ZZ-DR-CE-900575 4. ATK-ZZ-ZZ-DR-CE-900576 5. ATK-ZZ-ZZ-DR-CE-900577 6. ATK-ZZ-ZZ-DR-CE-900578 7. ATK-ZZ-ZZ-DR-CE-900579 8. ATK-ZZ-ZZ-DR-CE-900580	
Risk Level	- Atkins Base Line - Low Risk Atkins Sensitive - Medium Risk Atkins Private - High Risk Client Critical - Already Marked

Rev	Description	By	Date	Chk'd	Rev'd	Auth
P02	ISSUED FOR PLANNING	PM	15.09.26	IPR	GH	GH
P01	ISSUED FOR PLANNING	PM	09.09.26	PS	GH	GH

AtkinsRéalis

DUBLIN | CORK | GALWAY | DUNDALK

ATKINS HOUSE, 150 AIRSIDE BUSINESS PARK, SWORDS, DUBLIN, K67 K5W4.
Tel : +353 1 810 8000 Email : info.ie@atkinsrealis.com

Atkins House, 150-155 Airside Business Park, Swords, Co. Dublin
Tel (+353) 01 810 8000 Fax (+353) 01 810 8001

Unit 28, 2200 Cork Airport Business Park, Cork
Tel (+353) 021 429 0300 Fax (+353) 021 429 0360

1st Floor Technology House Parkmore Technology Park, Galway
Tel (+353) 091 786 050 Fax (+353) 091 779 830

Client	CASTLETHORN OLD CONNAUGHT UCL	
Project	OLD CONNAUGHT PHASE A1 LRD	

Purpose	FOR PLANNING				
Title	PROPOSED PUMP STATION & EMERGENCY 24hr STORAGE TANK DETAILED LAYOUT PLAN				
Original Scale	1:XXX at A1	Drawn	PM	Checked	PS
Date	31.09.26	Date	31.09.26	Date	31.09.26
Reviewed	PS	Authorised	GH		
Status	S4	Drawing Number	ATK-ZZ-ZZ-DR-CE-900573		Rev
				P02	