



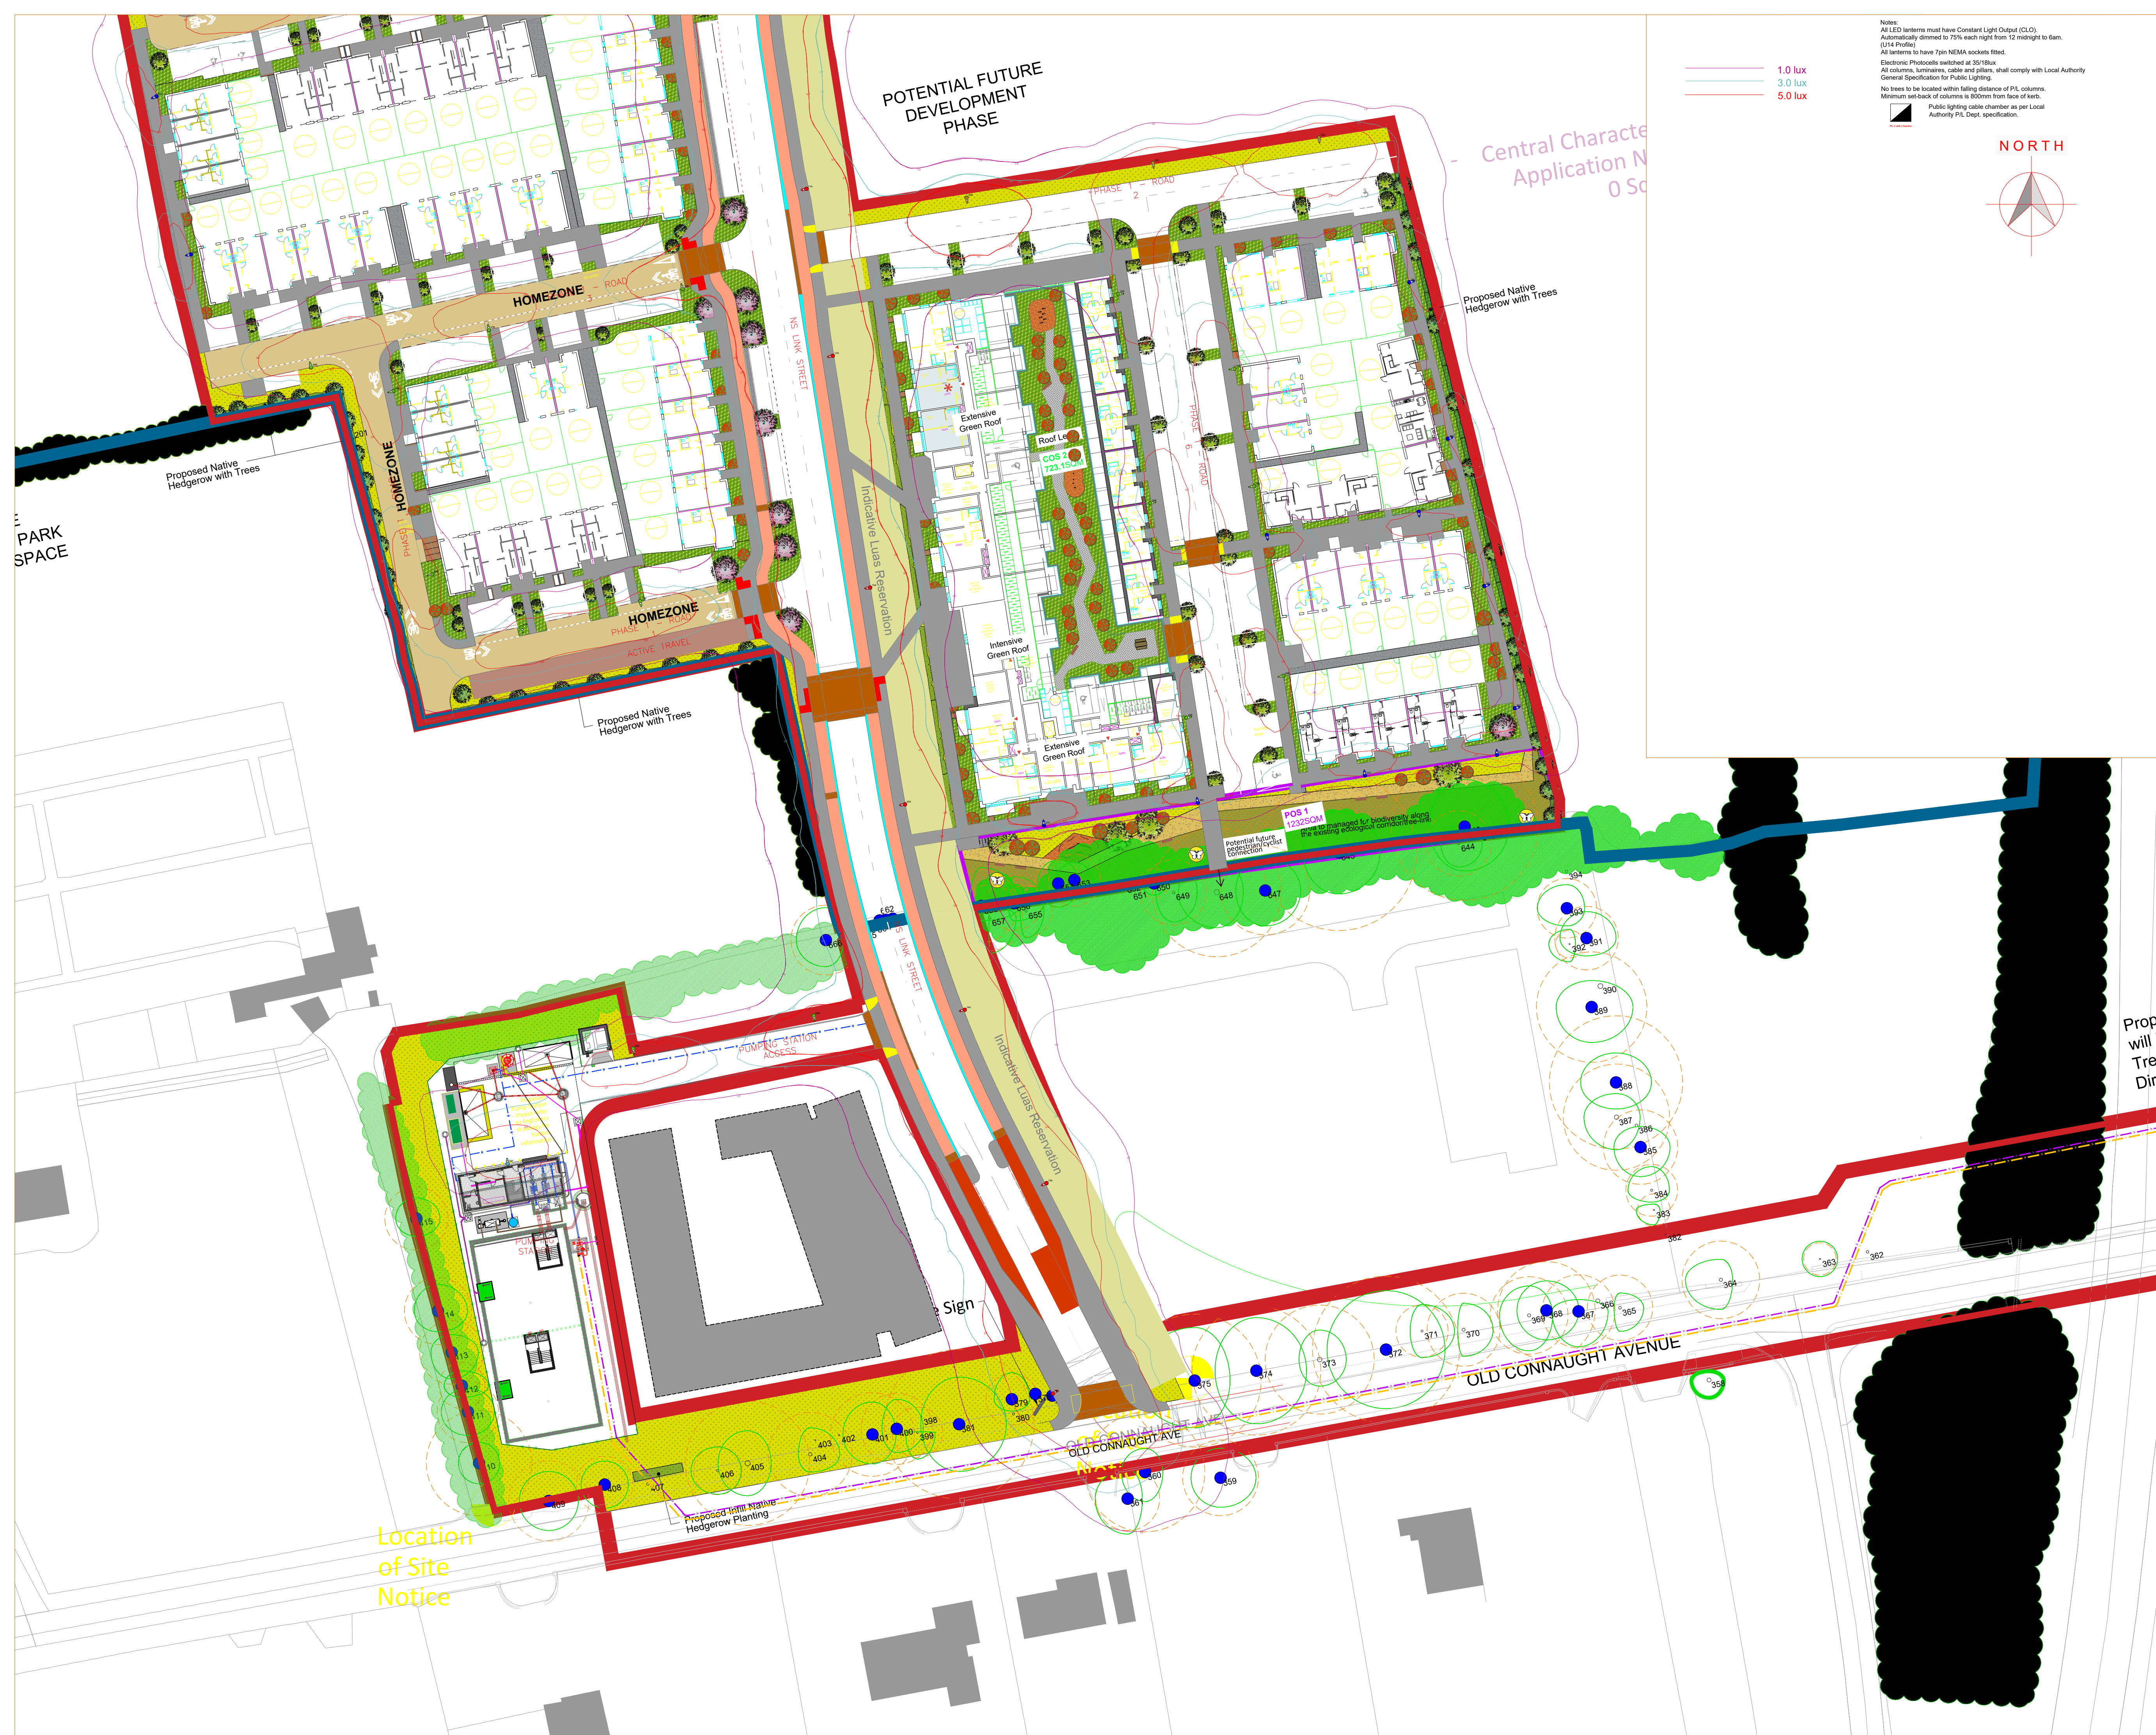

1.0 lux
3.0 lux
5.0 lux

Notes:
All LED lanterns must have Constant Light Output (C.L.O.).
Automatically dimmed to 75% each night from 12 midnight to 6am.
(U14 Profile)
All lanterns to have 7pin NEMA sockets fitted.
Electronic Photoeyes switched at 35/18lux
All columns, luminaires, cable and pillars, shall comply with Local Authority
General Specification for Public Lighting.
No trees to be located within falling distance of P.L. columns.
Minimum set-back of columns is 800mm from face of kerb.
Public lighting cable chamber as per Local
Authority P.L. Dept. specification.

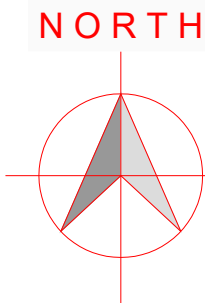



- Luminaire A P863-128-R2E-730-W3-650-83W
10m Column. Qty 15
- Luminaire B E950-28-P4A-730-C600-15W
6m Column. Qty 25
- Luminaire C E950-28-P4A-730-B2-C0250-7W
5m Raise & Lower Column. Qty 18
- Luminaire D P863-128-R2E-730-BB-W3-200-28W
8m Column. Qty 3
- Luminaire E E950-28-A2A-730-C600-15W
6m Column. Qty 4
- Luminaire F E950-28-F2A-730-C600-15W
6m column. Qty 1

2X6sq NYC/C cable laid in ducting to I.S.10101:2020.
Single wall ducting, colour red to be used
manufactured from high density polyethylene (H.D.P.E.),
107mm external diameter, having a wall thickness of 5mm.
This ducting to have the words "Street Lighting" stamped on
to be clearly legible at 1m intervals. The lettering to face upmost
in the trench. All works to Local Authority specification.
This is a crucial layout and not indicative of where ducts are to be laid.
Public Lighting Pillar (located at least 2m from ESB pillar)

Typical Base detail, to be checked
by site engineers.

COLUMN MOUNTING HEIGHT	12m	10m	8m	6m
COLUMN ROOT DEPTH	1.9m	1.7m	1.5m	1.0m
CABLE ENTRY DEPTH	0.3m	0.3m	0.3m	0.3m
ROOTING CONCRETE DEPTH				
COLUMN DOOR HEIGHT	1.5m	1.5m	1.5m	1.5m
COLUMN SLEEVE SIZE (mm) internal	450	400	400	300
EXCAVATION (width x length)	1000	800	600	400

Heavy Duty PVC or Concrete pipe
to size C

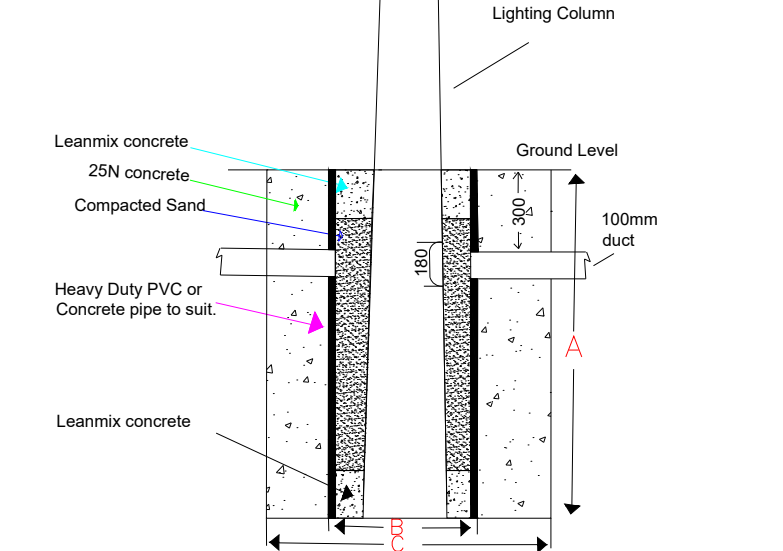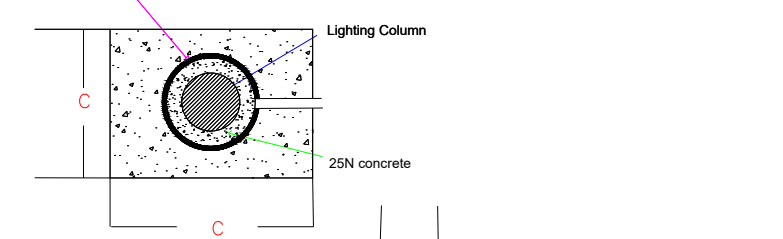

NOTES
THIS DRAWING IS THE INTELLECTUAL PROPERTY OF
AND IS COPYRIGHT (C) AND CAN NOT BE USED WITHOUT PRIOR CONSENT.

NO ACCOUNT IS TAKEN FOR THE BLOCKING EFFECT CAUSED BY BUILDINGS, TREES ETC.
THE CALCULATION SHOWN BY THIS DRAWING ASSUMES THAT THE WHOLE AREA BEING
CONSIDERED IS IN THE SAME PLANE, I.E. THERE ARE NO CHANGES IN GRADIENT OR
ELEVATION.

This drawing layout is based on calculated lighting levels, produced by Sabre Electrical Services Ltd., using Lighting
Reality software. Any alterations to the layout or luminaire type used for the lighting design calculations, will require
a revised lighting design to be carried-out. A redesign may require approval from the Local Authority Public Lighting
Dept. prior to any alterations/modifications being implemented on site.

Sabre
ELECTRICAL SERVICES LTD.
Specialist Contractors
PUBLIC LIGHTING - FLOOD LIGHTING - SPORTS LIGHTING - ESB DUCT PROVING

UNIT 11,
BELLVUE INDUSTRIAL ESTATE,
FINGLAS,
DUBLIN 11.
E - MAIL: design@sabrelighting.ie
robbie@sabrelighting.ie
PH: 01-811 0875

-	?	GS	CHK	-----
-	?	GS	CHK	-----
-	?	GS	CHK	-----
D	Red Line updated & Pump station added	AN	CHK	02-10-26
C	Red Line updated	AN	CHK	23-07-26
B	Red Line updated	AN	CHK	21-07-26
A	Title block updated	AN	CHK	21-07-26
REV	DESCRIPTION	INITS	CHKD	DATE

CLIENT/CUSTOMER
Castlethorn Old Conna ULC

PROJECT
Old Connaught Phase A1 LRD

TITLE
Public Lighting Layout

DRAWN
A.N

SCALE
1:500@A1

DATE
06-06-26

DRAWING NUMBER
SES 06526 Sheet 2

ISSUE
5

BASE DRAWING NUMBER

DRAWING ORIGIN

DO NOT SCALE FROM THIS DRAWING